




WEST ELEVATION SCALE 3/32"=1'-0"

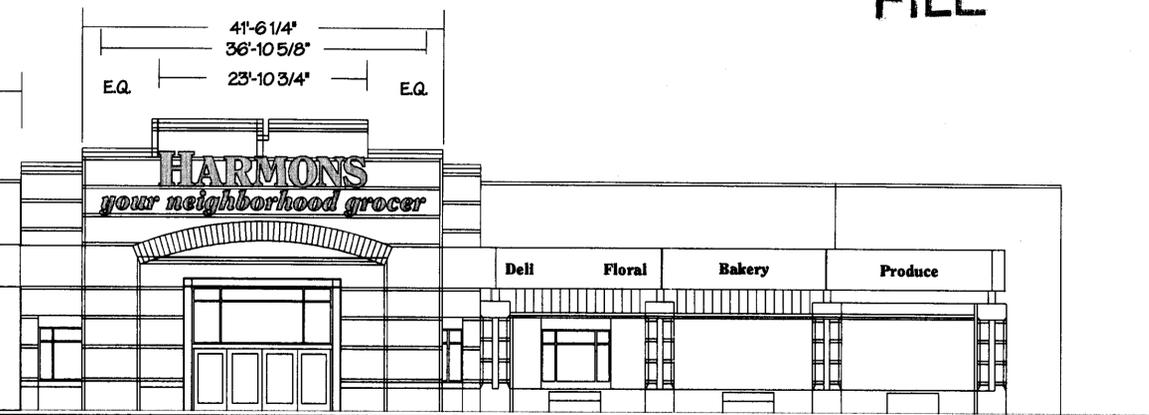

R-1 : ADDED "FLORAL" 5/16" DRIVE THRU CABINET & CHANGED LOW PROFILE
 R-2 : ADDED 43" STAND-OFFS TO NORTH ELEVATION LETTERS
 R-3 : CHANGED PHARMACY DRIVE THRU CABINET TO PAN CHANNEL LETTERS

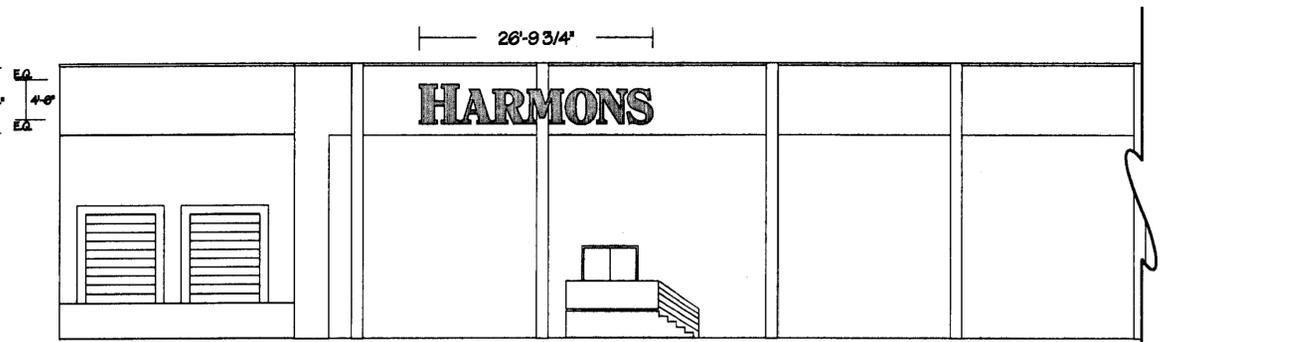

NORTH ELEVATION SCALE 3/32"=1'-0"

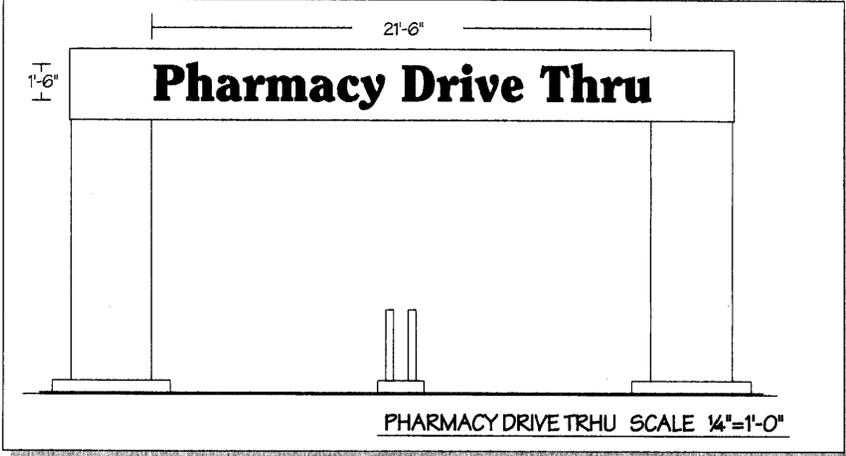

PHARMACY DRIVE THRU SCALE 1/4"=1'-0"

YESCO TO MANUFACTURE AND INSTALL (1) SET OF INTERNALLY ILLUM. PLEX FACE PANCHANNEL LETTERS READING (YOUR NEIGHBORHOOD GROCER).
 LETTER RETURNS TO BE 5" ALUM. PAINTED BLACK.
 ILLUM TO BE 15mm. 4500 COOL WHITE NEON. (NUMBER OF TUBES AS REQ'D)
 FACES TO BE YELLOW PLEX 2037 WITH 1" BLACK TRIM CAP.
 INSTALL LETTERS ON BUILDING ELEVATIONS AS SHOWN.
 THRU WALL WIRING TO REMOTE TRANSFORMERS. (NOTE) YESCO TO INSTALL SERVICE DOORS UNDERNEATH FASCIA BAND.
 SCALE 1/4"=1'-0"

CUSTOMER APPROVAL
 I have studied the above design drawing and find the following details acceptable.
 () Copy and Letter styles
 () Materials () Colors
 () Dimensions
 Customers Signature / Date

ELECTRICAL SPECIFICATIONS
 ILL. REQUIRED OTHER
 NON-ILL.
 20 AMP CIRCUITS REQUIRED
 ACTUAL AMP LOAD.
 120 VOLTS 277 VOLTS
 OTHER



your neighborhood grocer



YESCO TO MANUFACTURE AND INSTALL (1) SET OF SELF-CONTAINED INTERNALLY ILLUM. PLEX FACE PANCHANNEL LETTERS READING (HARMONS).
 LETTER RETURNS TO BE 9" ALUM. PAINTED BLACK.
 ILLUM TO BE 15mm. 4500 COOL WHITE NEON. (NUMBER OF TUBES AS REQ'D)
 FACES TO BE YELLOW PLEX 2037 WITH 2" BLACK TRIM CAP.
 INSTALL LETTERS ON BUILDING ELEVATION AS SHOWN.
 SCALE 1/4"=1'-0"



YESCO TO MANUFACTURE AND INSTALL (2) SETS OF SELF-CONTAINED INTERNALLY ILLUM. PLEX FACE PANCHANNEL 4'-6" LETTERS READING (HARMONS).
 LETTER RETURNS TO BE 9" ALUM. PAINTED BLACK.
 ILLUM TO BE 15mm. 4500 COOL WHITE NEON. (NUMBER OF TUBES AS REQ'D)
 FACES TO BE YELLOW PLEX 2037 WITH 2" BLACK TRIM CAP.
 INSTALL LETTERS ON BUILDING ELEVATION AS SHOWN W/ 4" STAND-OFFS.
 SCALE 1/4"=1'-0"



your neighborhood grocer

YESCO TO MANUFACTURE AND INSTALL (1) SET OF INTERNALLY ILLUM. PLEX FACE PANCHANNEL LETTERS READING (YOUR NEIGHBORHOOD GROCER).
 LETTER RETURNS TO BE 5" ALUM. PAINTED BLACK.
 ILLUM TO BE 15mm. 4500 COOL WHITE NEON. (NUMBER OF TUBES AS REQ'D)
 FACES TO BE YELLOW PLEX 2037 WITH 1" BLACK TRIM CAP.
 INSTALL LETTERS ON BUILDING ELEVATION AS SHOWN.
 SCALE 1/4"=1'-0"




Pharmacy Deli Floral Bakery Produce

YESCO TO MANUFACTURE AND INSTALL (1) SET OF INTERNALLY ILLUM. PLEX FACE PANCHANNEL LETTERS READING (VIDEO / PHARMACY DRIVE-THRU / DELI / BAKERY / MEATS / FLORAL / FOOD COURT / ONE HOUR PHOTO & PHARMACY DRIVE THRU).
 LETTER RETURNS TO BE 5" ALUM. PAINTED BLACK.
 ILLUM TO BE 15mm. 4500 COOL WHITE NEON.
 FACES TO BE YELLOW PLEX 2037 WITH 1" BLACK TRIM CAP.
 INSTALL LETTERS ON BUILDING ELEVATION AS SHOWN.
 SCALE 1/4"=1'-0"



Pharmacy Drive Thru

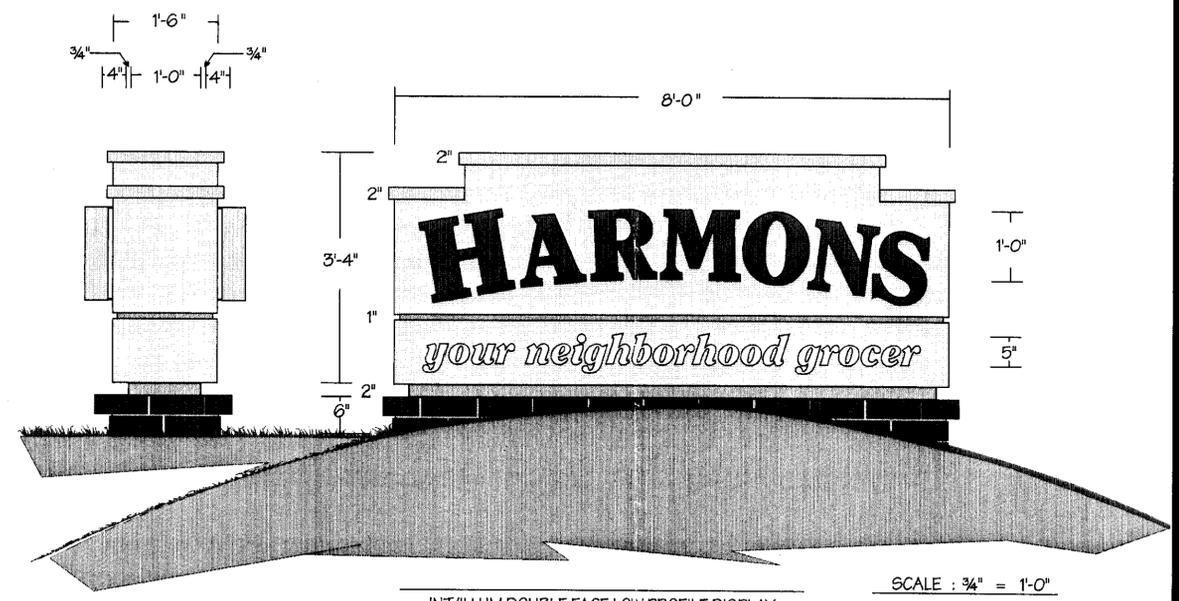

INT/ILLUM DOUBLE FACE LOW PROFILE DISPLAY

SCALE : 3/4" = 1'-0"

MANUF. & INSTALL 2 EA INT/ILLUM D/F LOW PROFILE CABINET DISPLAYS.
 CABINETS TO HAVE .090" ALUMINUM FACES PAINTED TO MATCH DESERT SAND BRICK.
 REVEALS TO BE PAINTED TO MATCH MOUNTAIN RED BRICK.
 "HARMONS" TO BE REVERSE CHANNEL LETTERS W/ FACES & 4" RETURNS PAINTED TO MATCH METAL SAMPLE DURA TECH 5000 MARINE GREEN.
 HALO/ILLUM W/ 6500 WHITE NEON.
 "SECONDARY COPY TO BE ROUTED OUT & BACKED W/WHITE PLEX INT/ILLUM W/ T-12 LAMPS.
 BASE TO BE CONSTRUCTED FROM MIDNIGHT BLACK BRICK TO MATCH BUILDING.
 INSTALL W/ DIRECT BURIAL EMBEDMENT

APPROVED

UTAH CONTRACTOR LICENSE NO. 22-2567-5501

SALT LAKE DIVISION
YESCO
YOUNG ELECTRIC SIGN COMPANY
 1148 So. 300 W. S.L.C. Utah 84101 (801) 457-8481

© THIS DRAWING WAS CREATED TO ASSIST YOU IN VISUALIZING OUR PROPOSAL. THE ORIGINAL IDEAS HEREIN ARE THE PROPERTY OF YOUNG ELECTRIC SIGN COMPANY. PERMISSION TO COPY OR REUSE THIS DRAWING CAN ONLY BE OBTAINED THROUGH A WRITTEN AGREEMENT WITH YESCO. SEE YOUR SALES REPRESENTATIVE OR CALL THE NEAREST OFFICE OF YOUNG ELECTRIC SIGN COMPANY.

PROJ. APPROVAL	CLIENT	SALES	DESIGN	ESTIMATING	ENGINEERING	EXPECTING
DATE	10/24/2000					
BY						
DRAWINGS	ORIG. DES.	REVISIONS	DESIGN NO.	DATE	SCALE	SHEET NO.
			00-1520	7-7-00	NOTED	1 OF 1
			R-1	8-11-00		
			R-2	8-24-00		
			R-3	8-24-00		
FIRM NAME/LOCATION ADDRESS	HARMONS SOUTH JORDAN UT.					
REGISTRATION NUMBER	00-1520					
SALES PERSON	PAYNE					
W.D. NUMBER	NOTE: COST FOR PROVIDING NECESSARY MATERIALS IS NOT INCLUDED IN THIS QUOTE.					